



H:\CADD\Current\ENV-Infra\Muscoy\Final Design_As Builts\M2.dwg User: msterfingr Plotted: May 24, 2006 - 10:19am Last Save: May 24, 2006 - 9:47am

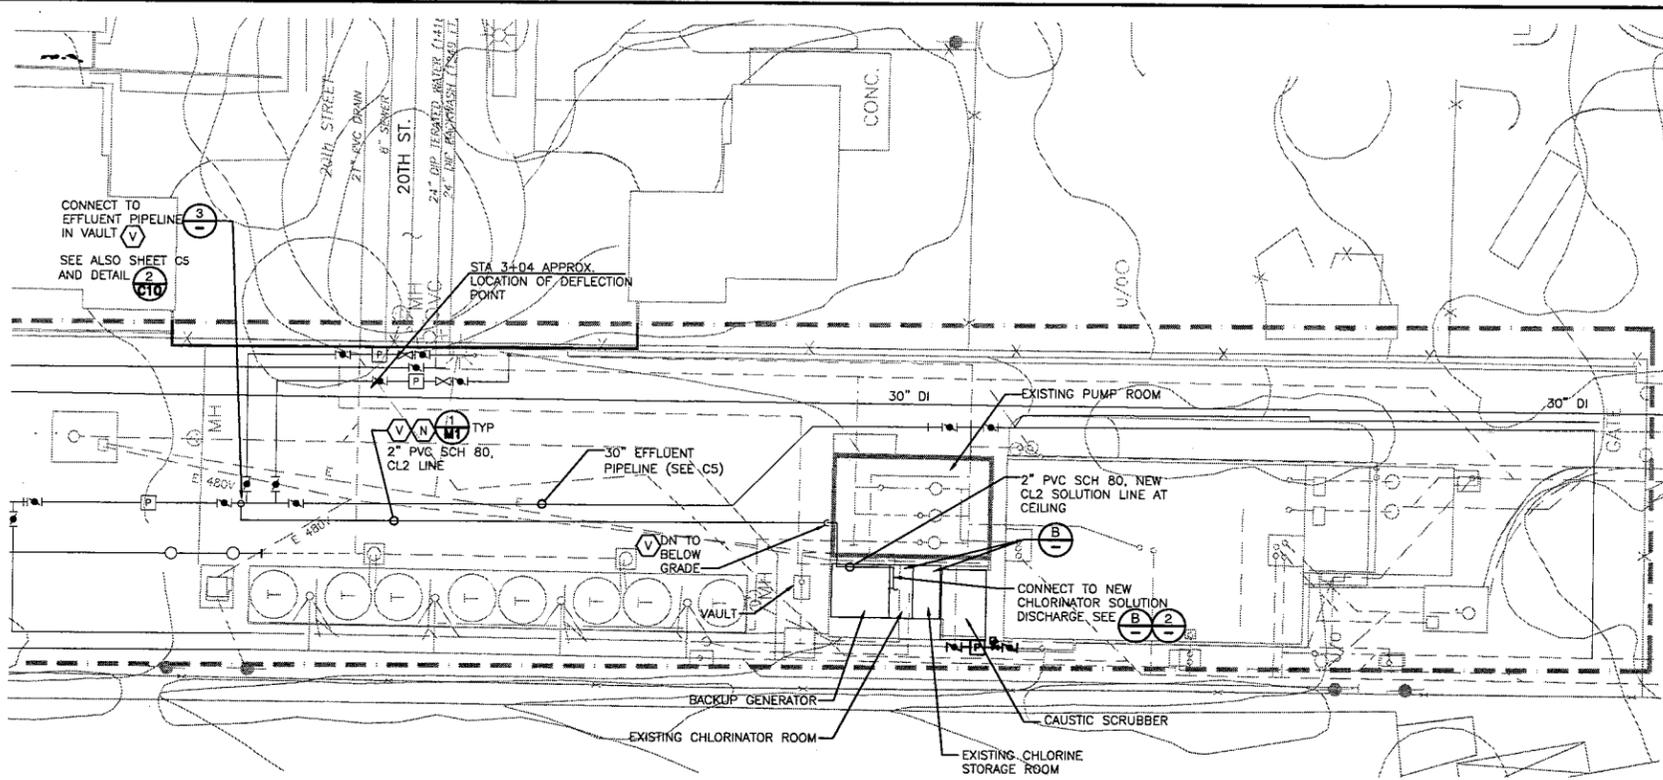


SITE PLAN (A) (M2)
1"=20'-0"

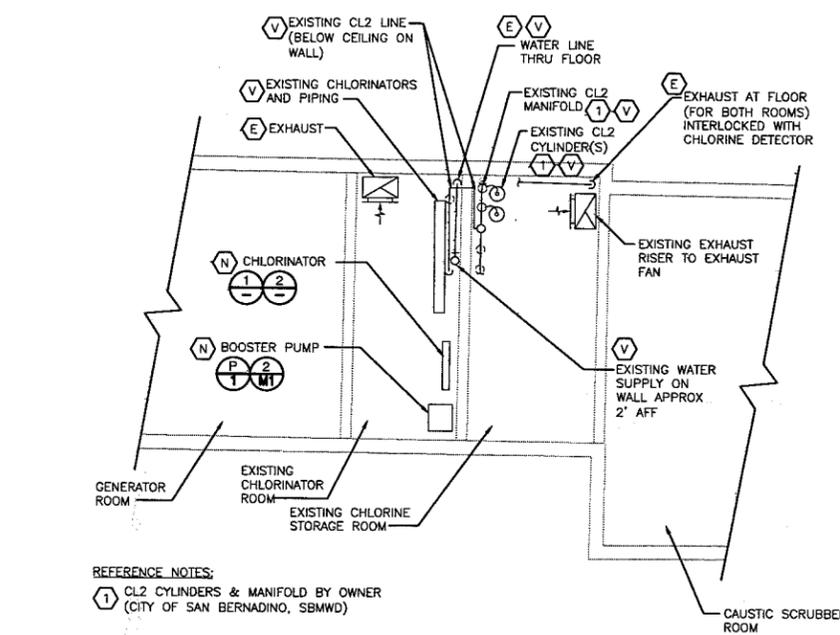

REFERENCE NOTES:
 1 CL2 CYLINDERS & MANIFOLD BY OWNER (CITY OF SAN BERNARDINO, SBMWD)




ENLARGED VIEW (B) (M2)
1/4"=1'-0"

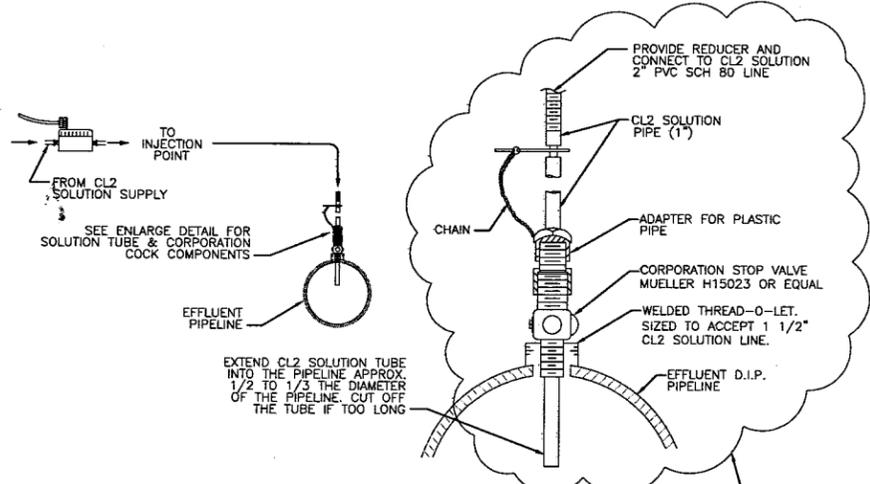


CHLORINE INJECTION AT EFFLUENT PIPELINE (3) (M2)
N.T.S.

SEE CHANGE ORDER NO. 32

IF SHEET IS LESS THAN 24" x 36" IT IS A REDUCED PRINT. SCALE REDUCED ACCORDINGLY.

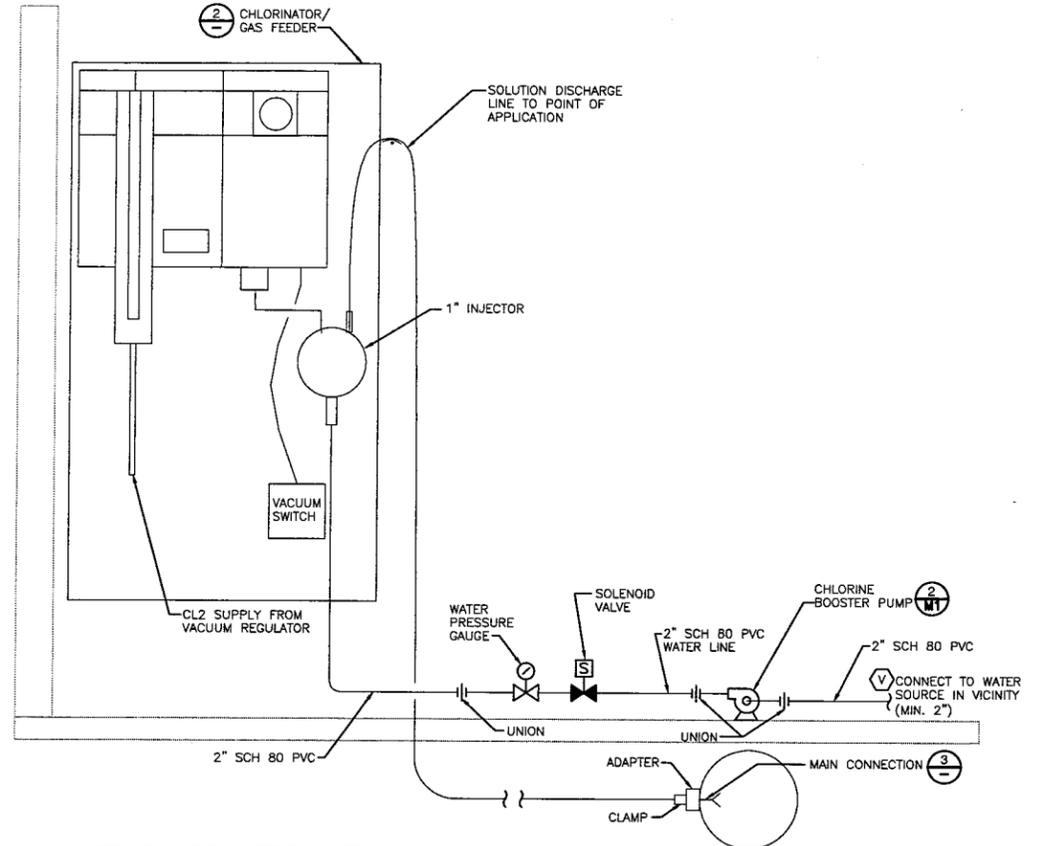

NEW CHLORINATOR INSTALLATION SCHEMATIC (1) (M2)
N.T.S.

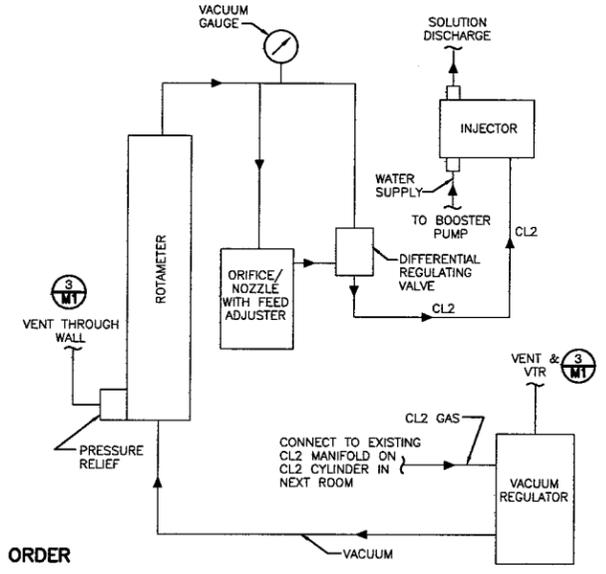

PROVIDE ALL INTERCONNECTING PIPING PER MANUFACTURER'S RECOMMENDATIONS. SUBMIT SHOP DRAWING FOR APPROVAL.

CHLORINATOR FLOW DIAGRAM (2) (M2)
N.T.S.

RECORD DRAWINGS

NO.	DATE	DESCRIPTION	NO.	DATE	DESCRIPTION
1	11/05	RECORD REVISION			
REVISIONS					

DESIGNED BY: DJ
 DRAWN BY: BUR
 CHECKED BY: DHD



MUSCOY OU REMEDIAL DESIGN
 19th STREET PLANT & ENCANTO PARK PUMPING PLANT
 NEWMARK GROUNDWATER CONTAMINATION SUPERFUND SITE

19TH STREET PLANT MECHANICAL PLANS AND DETAILS CHLORINE INJECTION SYSTEM			
SCALE	DATE	DWG. FILE	SHEET NO.
AS NOTED	8/14/03	M2.DWG	M2